


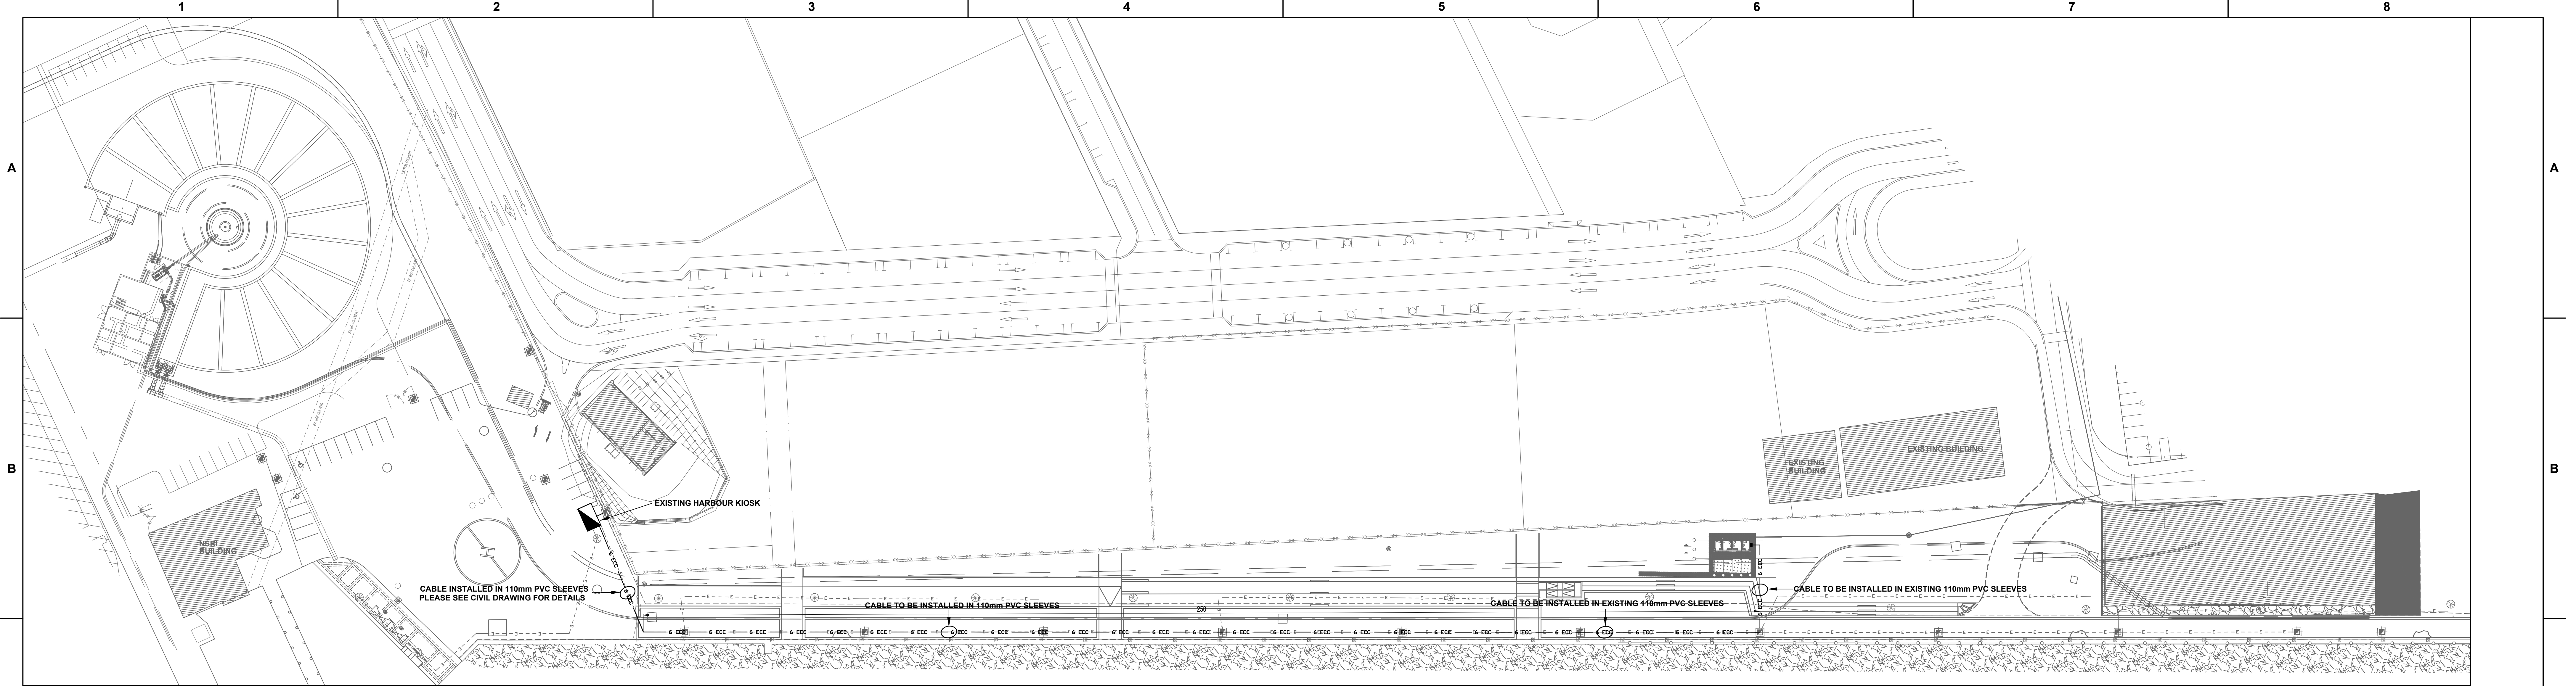

PROPOSED NORTH GROYPE LIGHTING LAYOUT
SCALE 1: 500

- ELECTRICAL NOTES :**
- THIS DRAWING FOR ELECTRICAL LIGHTING & POWER ONLY.
 - A CERTIFICATE OF COMPLIANCE TO BE COMPLETED AND SUBMITTED BY THE CONTRACTOR ON COMPLETION OF WORK.
 - ELECTRICAL, DATA AND COMMS AND FIRE SUB- CONTRACTORS TO CO-ORDINATE ALL REQUIREMENTS FOR WIREWAYS, CONDUIT AND OTHER SERVICES THAT ASSOCIATED WITH THE EQUIPMENT (CONTRACTORS DESIGN).
 - ALL WORK MUST COMPLY WITH THE GENERAL REQUIREMENTS OF SANS 10142-1 (as amended). THE CONTRACTOR AND PANEL MANUFACTURER IS REFERRED SPECIFICALLY TO CLAUSE 6.6/6.6.2/6.6.3/6.6.4 AND 6.6.5.
 - ALL ALTERNATIVES (OR SIMILAR) OF LIGHTING AND FIXTURES TO BE ACCEPTED BY ELECTRICAL ENGINEER PRIOR TO ORDERING.
 - THE CONTRACTOR SHALL DO AN ASSESSMENT OF THE EXISTING ELECTRICAL INFRASTRUCTURE AND DO NECESSARY TEST TO ENSURE THAT THE SYSTEM HAS POWER TO THE EXISTING INFRASTRUCTURE THE TEST SHALL INCLUDE BUT NOT LIMITS. CABLES, CIRCUIT BREAKERS, EARTHING CONDUCTORS THAT FEED POLES NO: 13,14,15,16.
 - THE CONTRACTOR SHALL DO ALL THE ALTERATIONS ON THE EXISTING HARBOR KIOSK TO SUIT THE NEW FEEDING ARRANGEMENT AS PER THE DRAWING

LEGEND	
	EXISTING LOW VOLTAGE KIOSK
	PROPOSED 6mm², 2 CORE ECC PVC SWA CABLE, TO BE INSTALLED INTO THE EXISTING 110mm PVC SLEEVES AND EXISTING PIPE AND CHAMBER.
	EXISTING MANHOLE FOR PIPE AND CHAMBER
	ELECTRICAL DISTRIBUTION BOARD, SURFACE MOUNTED (IP65)

NOTES	
1. DO NOT SCALE DRAWING - ONLY DIMENSIONS SHOWN TO BE USED.	
2. THE CONTRACTOR SHALL VERIFY ALL CONDITIONS, DIMENSIONS AND LEVELS ON THE SITE AND NOTIFY THE NEC SUPERVISOR OF ANY VARIATIONS BEFORE CONSTRUCTION.	
DRAWING NO.	REFERENCE
REFERENCE DRAWINGS	

CONTRACTOR / CONSULTANT				TRANSNET NATIONAL PORTS AUTHORITY				Transnet National Ports Authority			
TITLE	NAME	SIGN	DATE	TITLE	NAME	SIGN	DATE	TRANSNET LTD (TRADING AS TRANSNET CAPITAL PROJECTS) REG. NO. 198600000000			
				DRAWN	PM		08 05 25	237 MAHATMA GANDHI ROAD			
				CHECKED	SM		08 05 25	DURBAN			
				DESIGNED	PM		08 05 25	P.O. BOX 1073, DURBAN			
				CHECKED	SD		08 05 25	TEL: 031 361 1000			
								FAX: 0865 770815			
OPERATING DIVISIONS				PR.ENG. / PR.TECH./PR. ARCH				PORT OF DURBAN			
TITLE	NAME	SIGN	DATE	NAME	S. SEVDAYAL		DATE	UPGRADE OF THE NORTH GROYPE: CONSTRUCTION OF ABLUTION BLOCK			
OA	ISSUED FOR TENDER	PM	SD	SS	14-05-2025			PROPOSED CABLE RETICULATION LAYOUT			
NO.	DESCRIPTION	BY	CHKD	APPD	DATE	SIGNATURE	2009/0129	PROJECT NUMBER			
REVISIONS				SCALE: AS SHOWN				A0X0N048110000E0LA00030010A0			
This Document including all design and information herein is Confidential Intellectual Property of Transnet. Copyright and all other rights are reserved by Transnet. This Document may only be used for its intended purpose.								DRAWING NO. SHEET REV ID			